
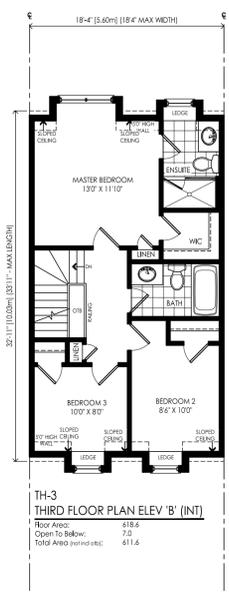
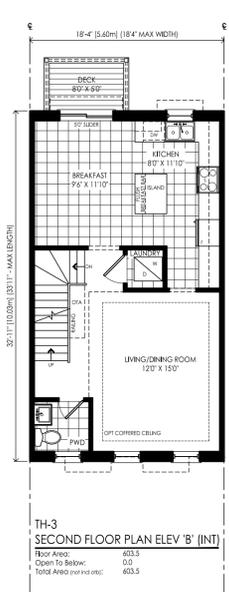
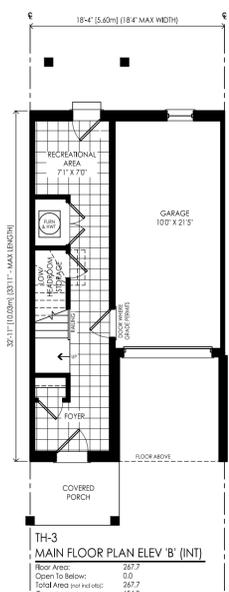
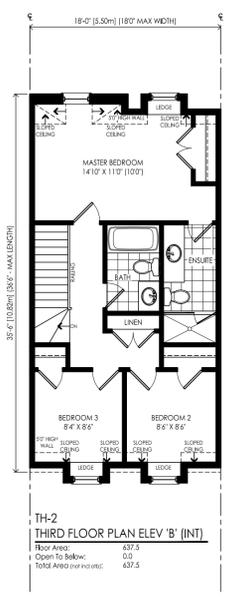
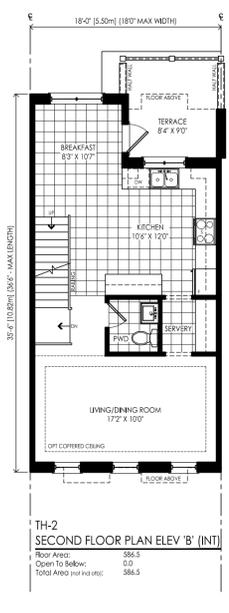
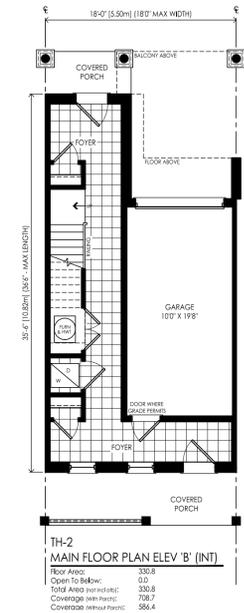
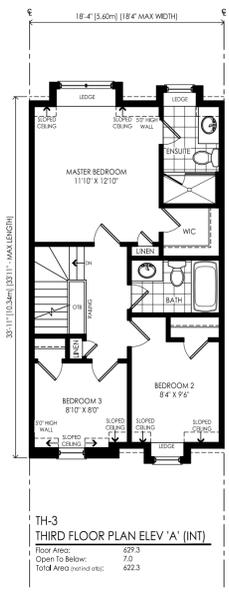
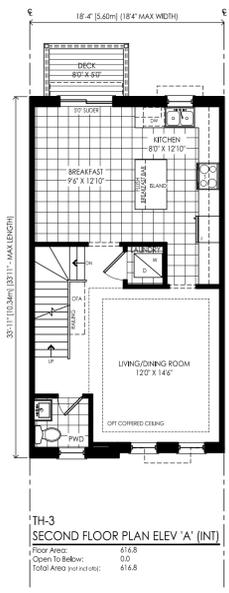
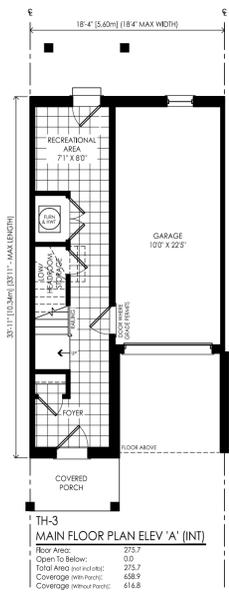
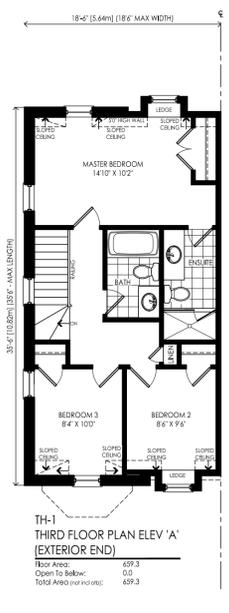
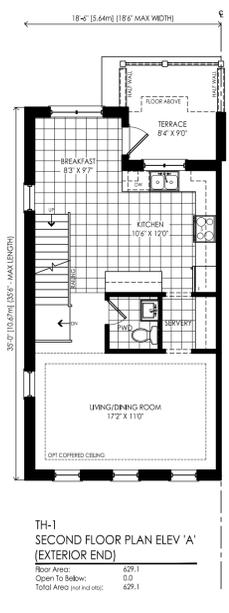


# ATTACHMENT 7

THESE DRAWINGS ARE NOT TO BE SCALED.  
ALL DIMENSIONS MUST BE VERIFIED BY CONTRACTOR PRIOR TO COMMENCEMENT OF ANY WORK. ANY DISCREPANCIES MUST BE REPORTED DIRECTLY TO SRN ARCHITECTS INC.

PROJECT CONSULTANTS:

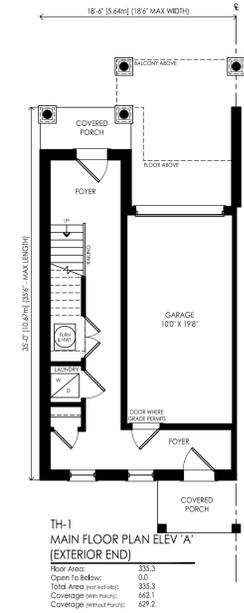

**LEGEND**

SMOKE ALARM (S)	CARBON MONOXIDE ALARM (CM)
WATERPROOF DUPLEX OUTLET	EX. LIGHT FIXTURE (WALL MOUNTED)
VENTS AND INLETS	HYDRO METER
HOSE BB	GAS METER
EXHAUST FAN	FLOOR DRAIN
COLD CELLAR VENT (C)	SOLID BEARING WALL
STOVE VENT	POUR LOAD
FIRE PLACE VENT	FLAT ARCH
DRYER VENT	2 STORY WALL
D.J. DOUBLE JOIST	UIS UNDER SIDE
P.T. PRESSURE TREATED LUMBER	FG FINED GLAZING
G.T. GIBBER TRUSS	CB GLASS BLOCK
A.F.F. ABOVE FINISHED FLOOR	BG BLACK GLASS
BBFM BEAM BY FLOOR MANIF.	(FL) FLUSH
'DO' REPEAT SAME JOIST SIZE	(DR) DROPPED

**ISSUED OR REVISION COMMENTS**

NO.	DESCRIPTION	DATE	DWN	CHK
1	ISSUED FOR SPA	11 APR 16	SD	SD
2	ISSUED FOR SPA	26 AUG 17	NM	NM
3	ISSUED FOR VAUGHAN HERITAGE	13 MAR 19	NM	NM

**RN DESIGN LTD.**  
 8395 JANE STREET, SUITE 203  
 VAUGHAN, ONTARIO, L4K 5Y2  
 T: 905-738-3177 | F: 905-738-5449

CLIENT  
**LAURIER HARBOUR (KEELE) INC.**

PROJECT LOCATION  
**9785, 9797 KEELE STREET  
 VAUGHAN, ONTARIO**

DRAWING  
**FLOOR PLANS**

DATE APR 11/16	SCALE 1/8"=1'-0"
DRAWN BY SD	CHECKED BY SD
PROJECT NUMBER 17005	DRAWING NUMBER SPA 201